


DATE	REV	DESCRIPTION
00-00	0000	0

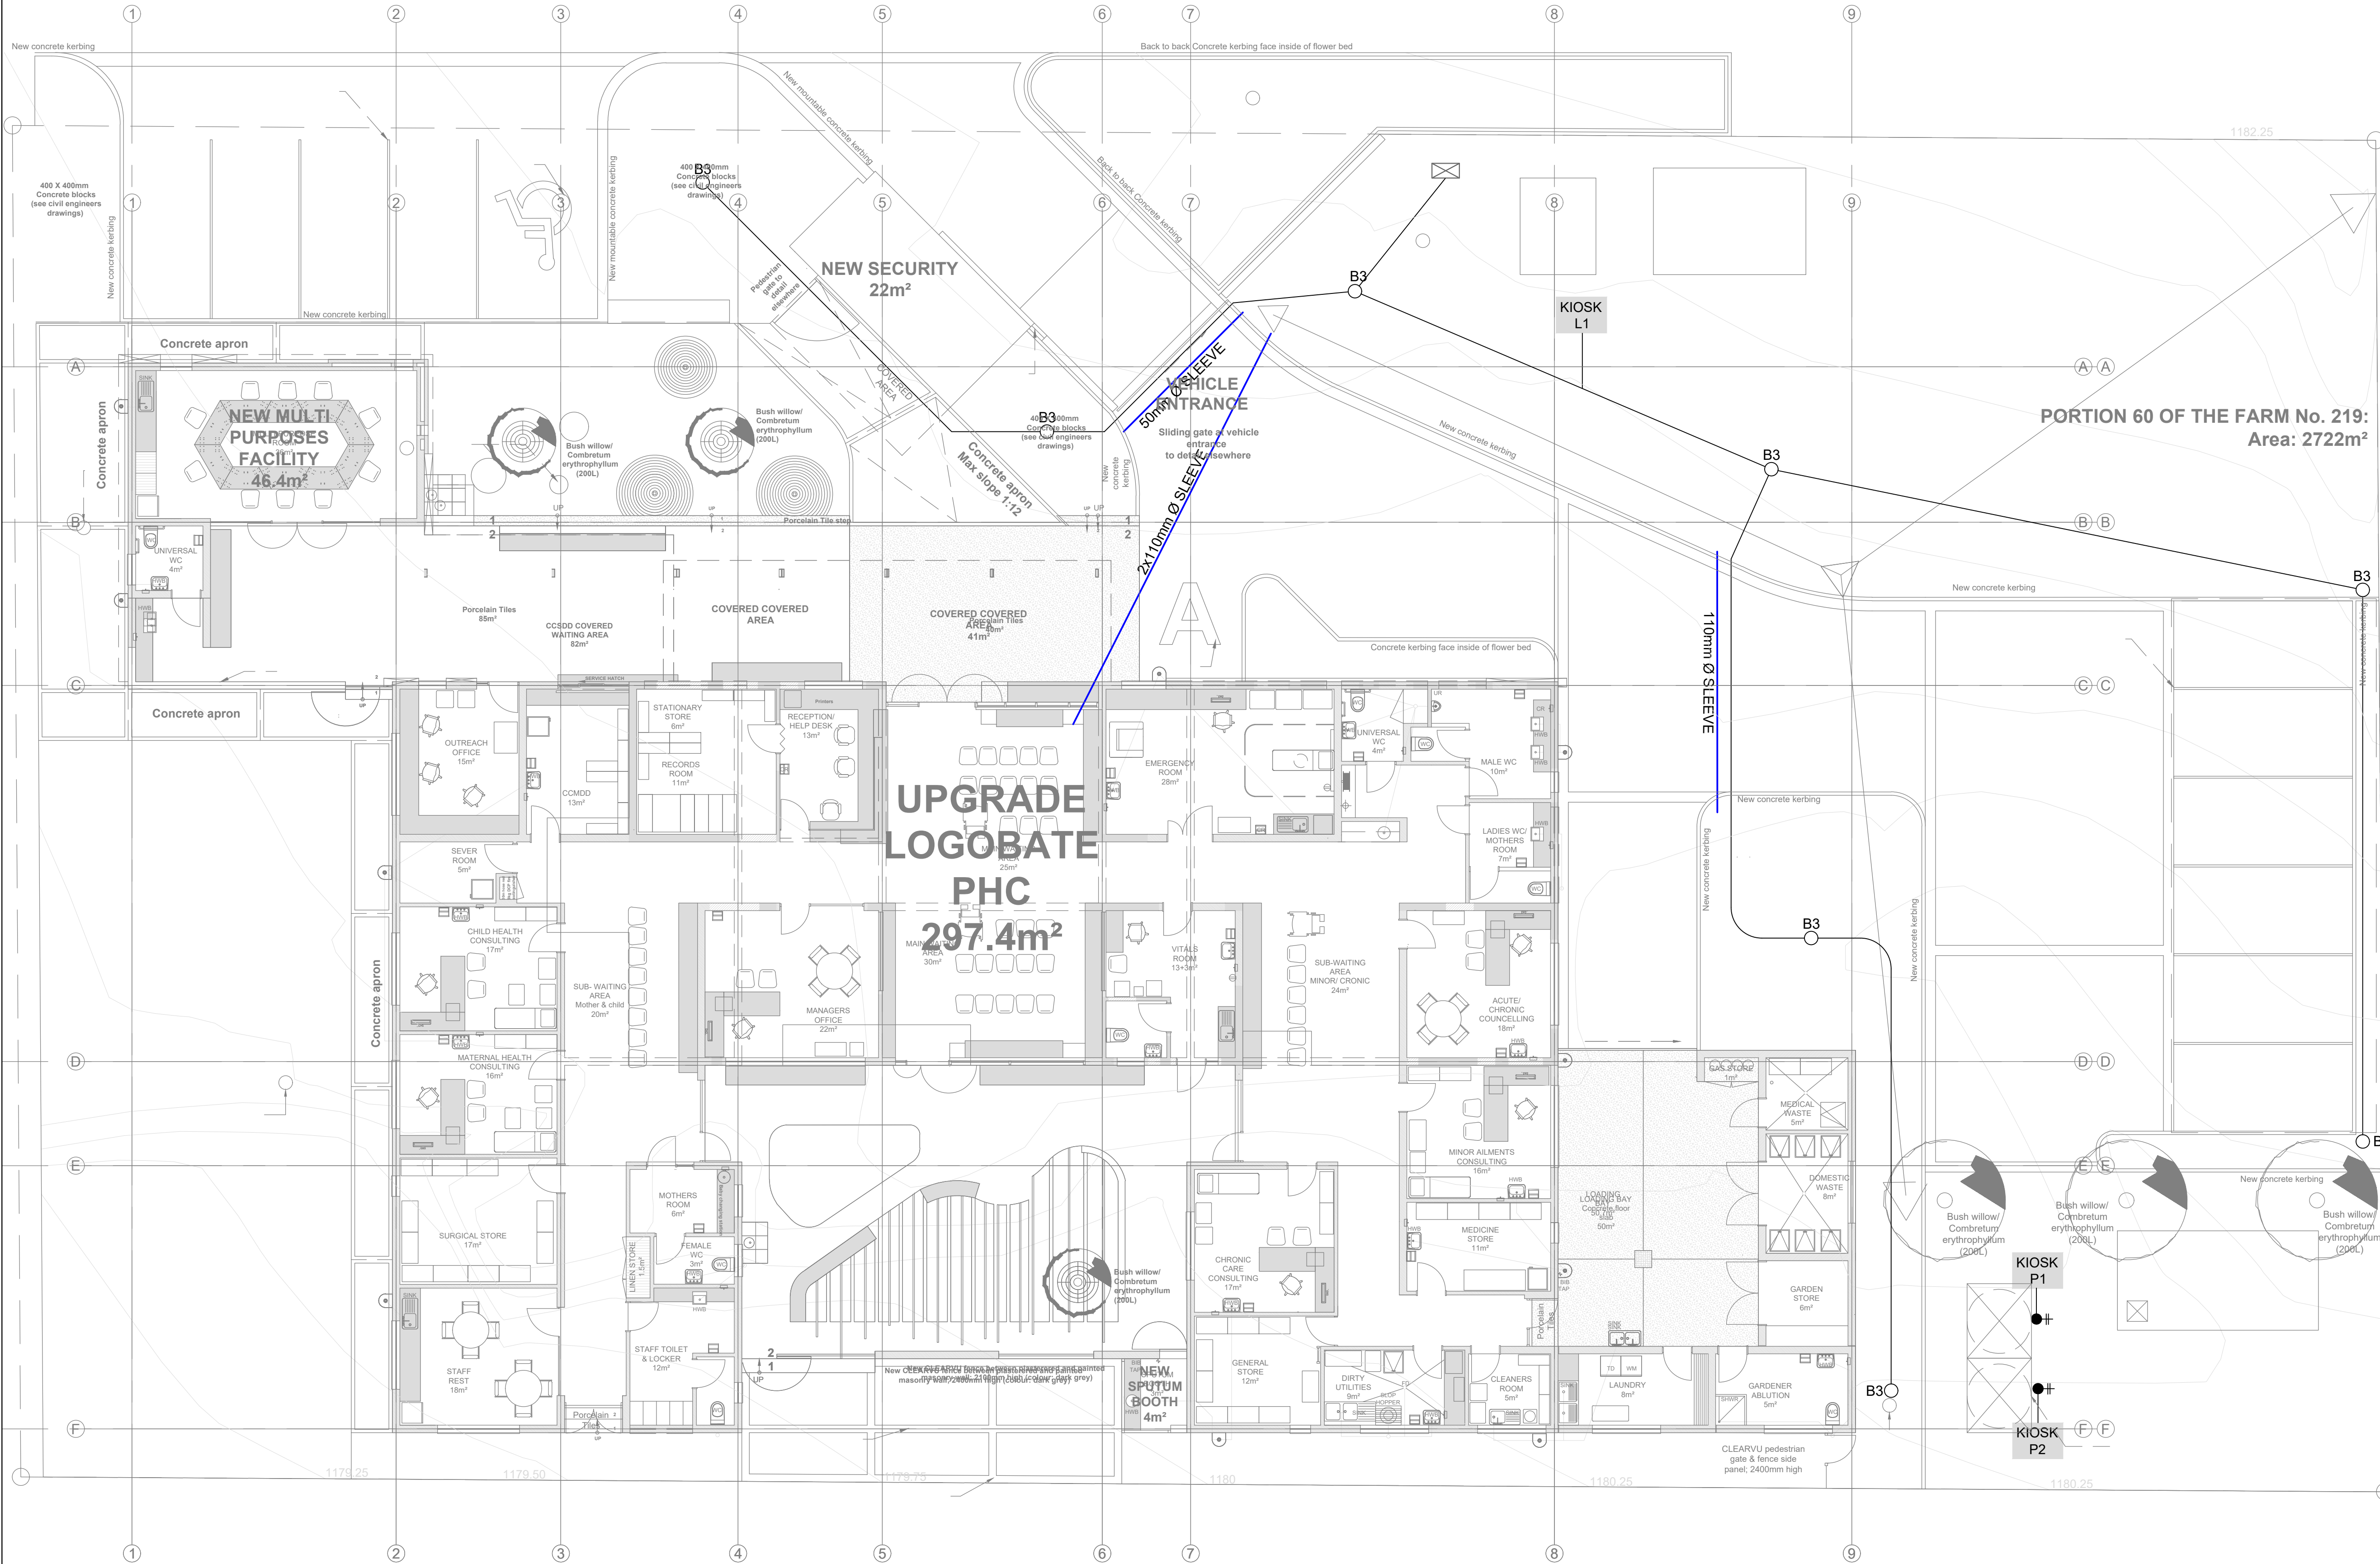

CONCEPT DRAWING	TENDER DRAWING	CONSTRUCTION DRAWING	AS-BUILT DRAWING
☐	☐	☒	☐

PROJECT NOTES			
GENERAL NOTES			
LEGEND			
	DISTRIBUTION BOARD		
	KIOSK		
	55W LED POST TOP		
	MANHOLE		
	110mm Ø SLEEVE		
	50mm Ø SLEEVE		
	10mm² x 3 CORE CABLE		
CONSULTING ENGINEERS	 39 Brebner Street TEL:+27 (0)51 403 8596 Westdene 9301 FAX:+27 (0)51 430 1776 e-mail: admin@fceconsultingengineers.co.za		
PROJECT TITLE	LOGOBATE PHC: ADDITIONS & ALTERATIONS TO EXISTING PORTION 60 ON FARM 219 KURUMAN NORTHERN CAPE		
CLIENT DETAILS	 Province of the NORTHERN CAPE Department of Health		
CLIENT APPROVAL			
DRAWING DESCRIPTION	SITE PLAN		
DESIGN	CS. ESTERHUYSEN Pr Tech Eng: 200970285		
CHECKED	CS. ESTERHUYSEN Pr Tech Eng: 200970285		
SCALE	1:100	DRAWN R.M	DATE JUN 2024
PROJECT NUMBER	EE1311C	DRAWING NUMBER	1E